

INITIAL SIGNED

No.

Consultants

DATE

REVISIONS

DESIGN:

SCALE:

DATE:

Manager, Design & Construction Linear Underground Infrastructure Basement Flooding Protection Program

MICHAEL D'ANDREA, P.ENG.

EXECUTIVE DIRECTOR

Engineering & Construction Services

CR

DRAFTING:

HOR 1:200 VER 1:100

11/05/2015

CR


CHECK:


DRAWING


NUMBER:


CONTRACT No.


SHEET No. 1 OF 4

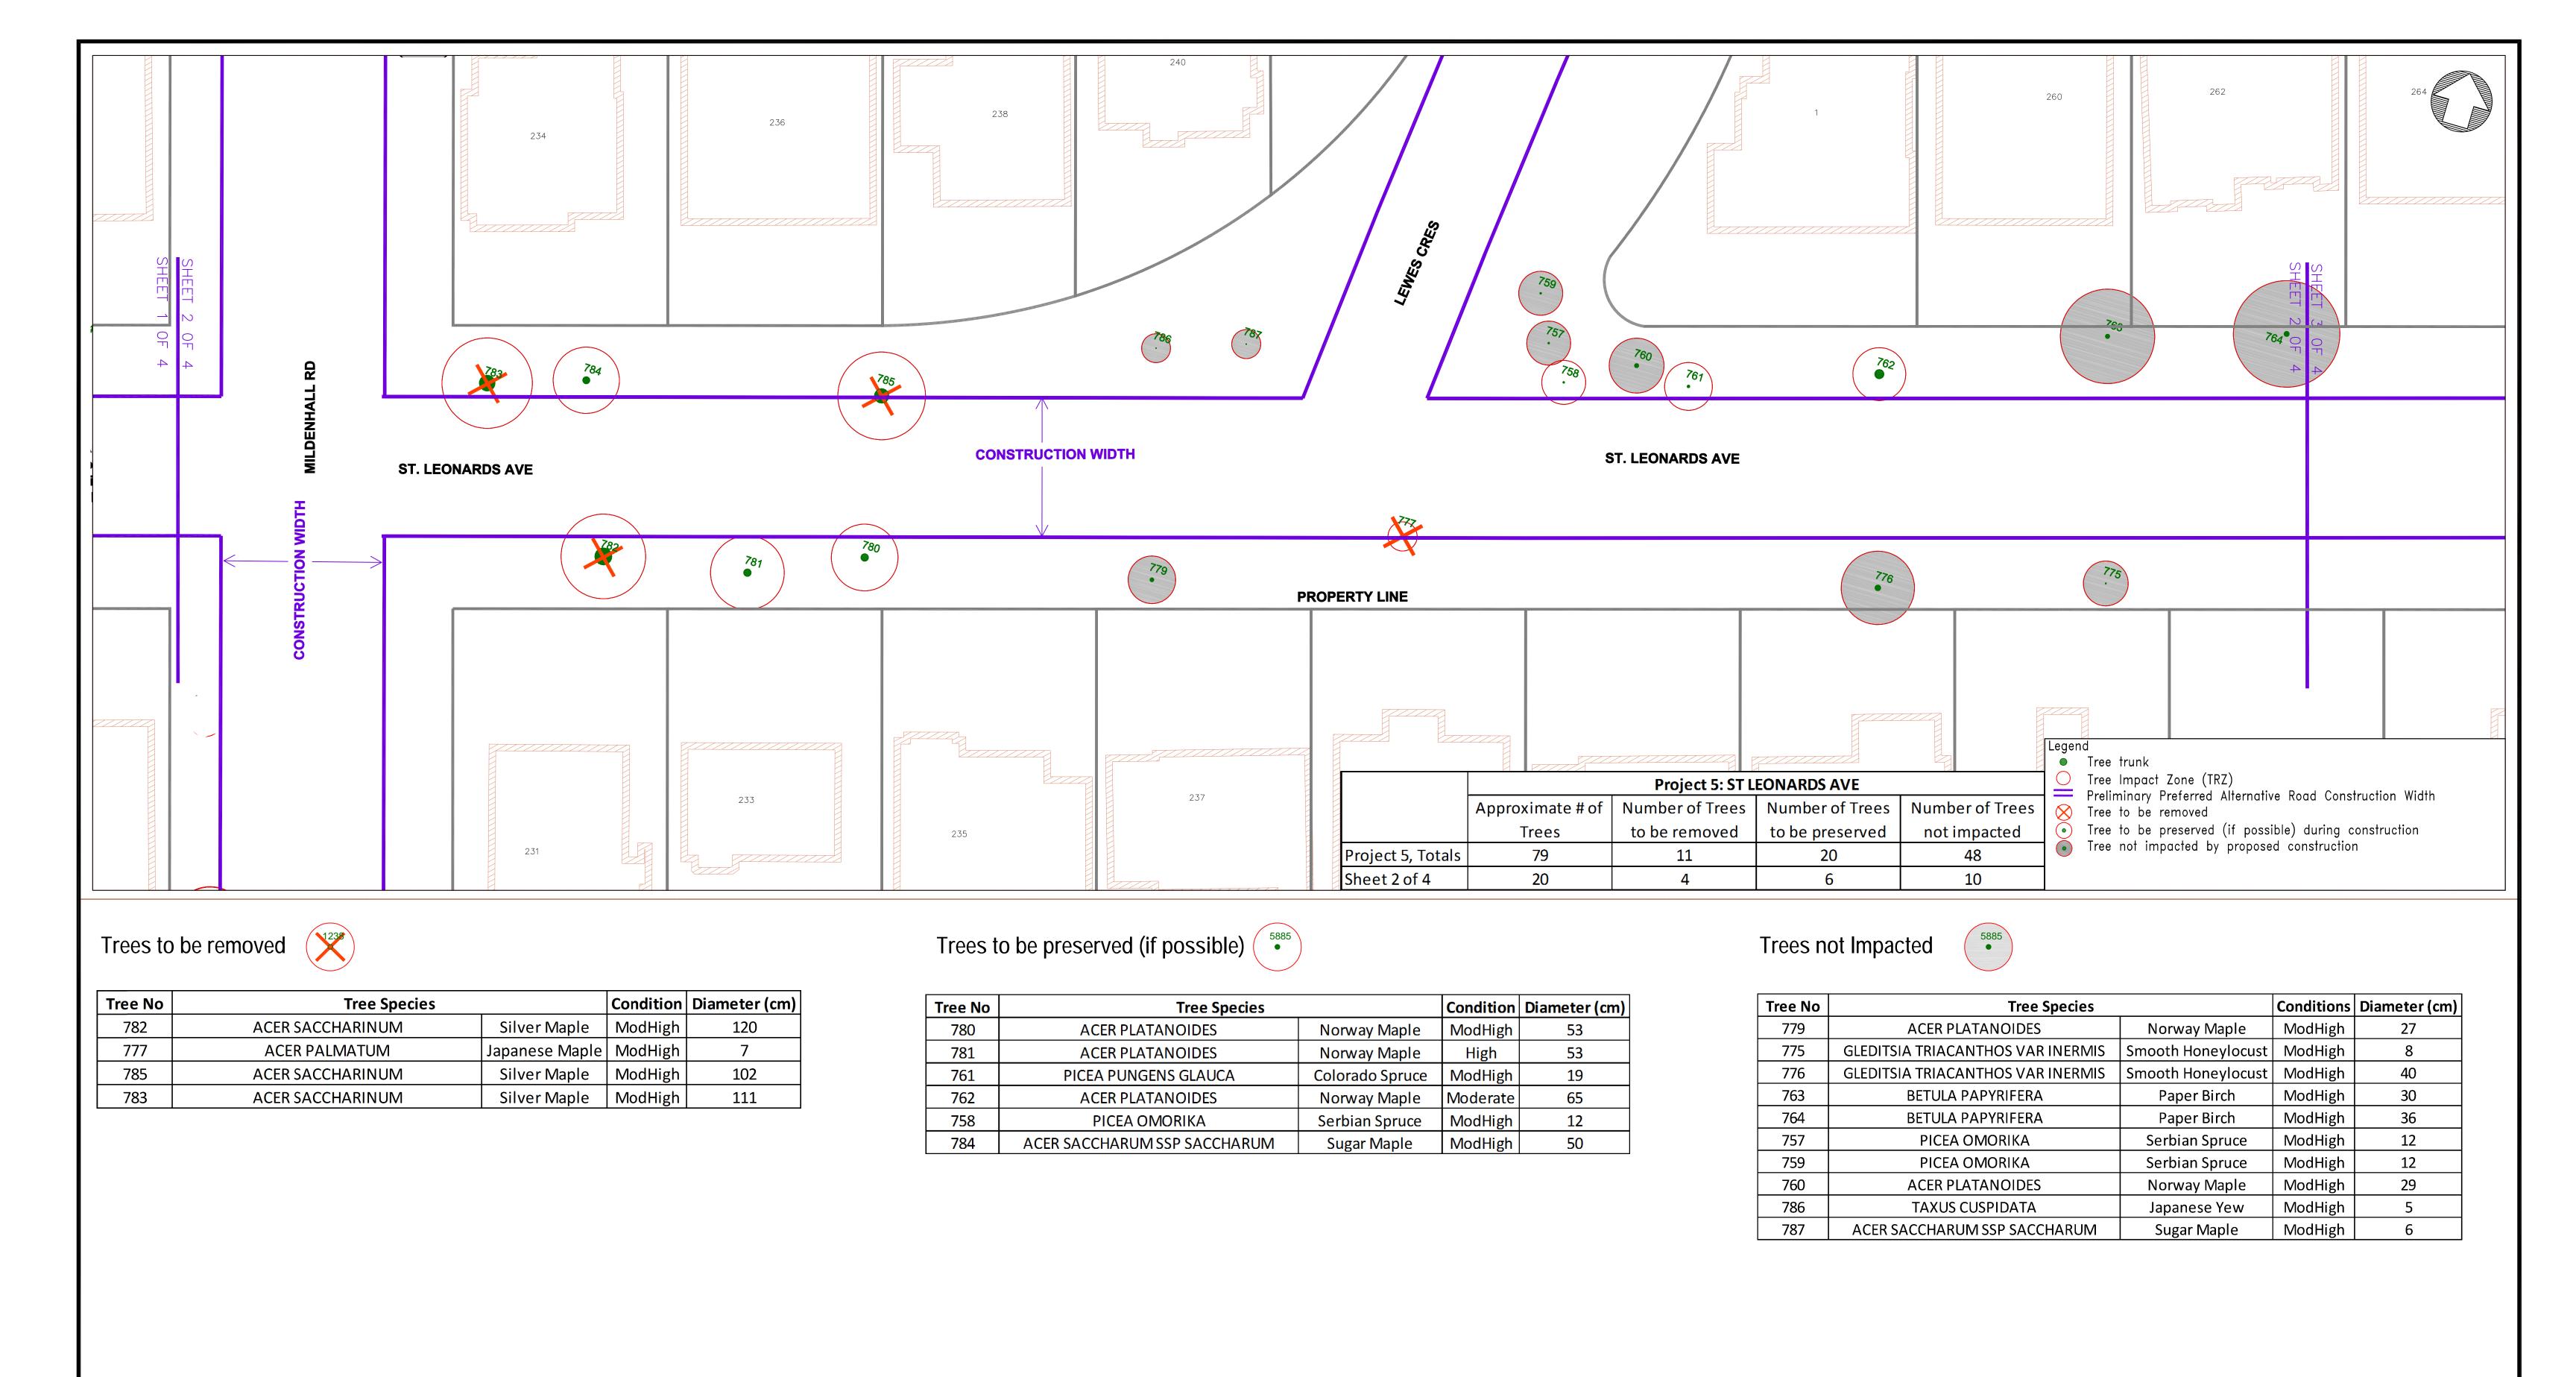


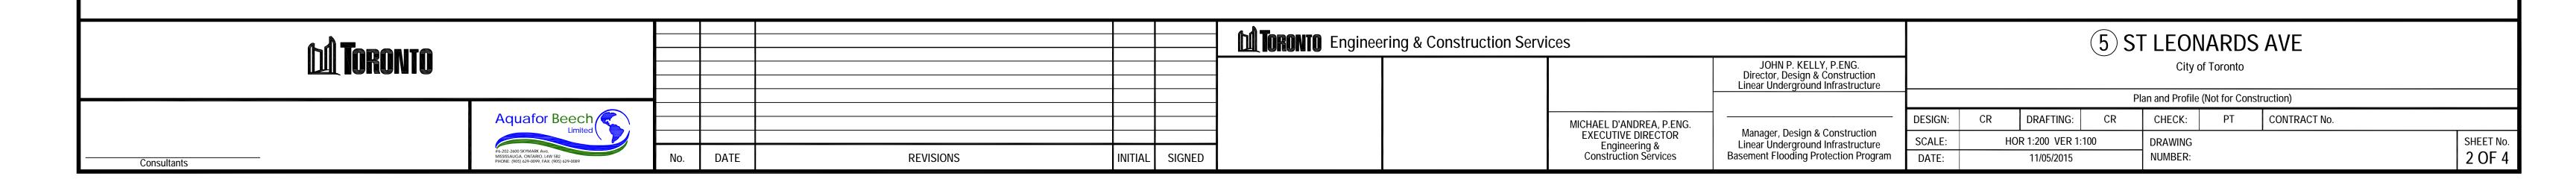

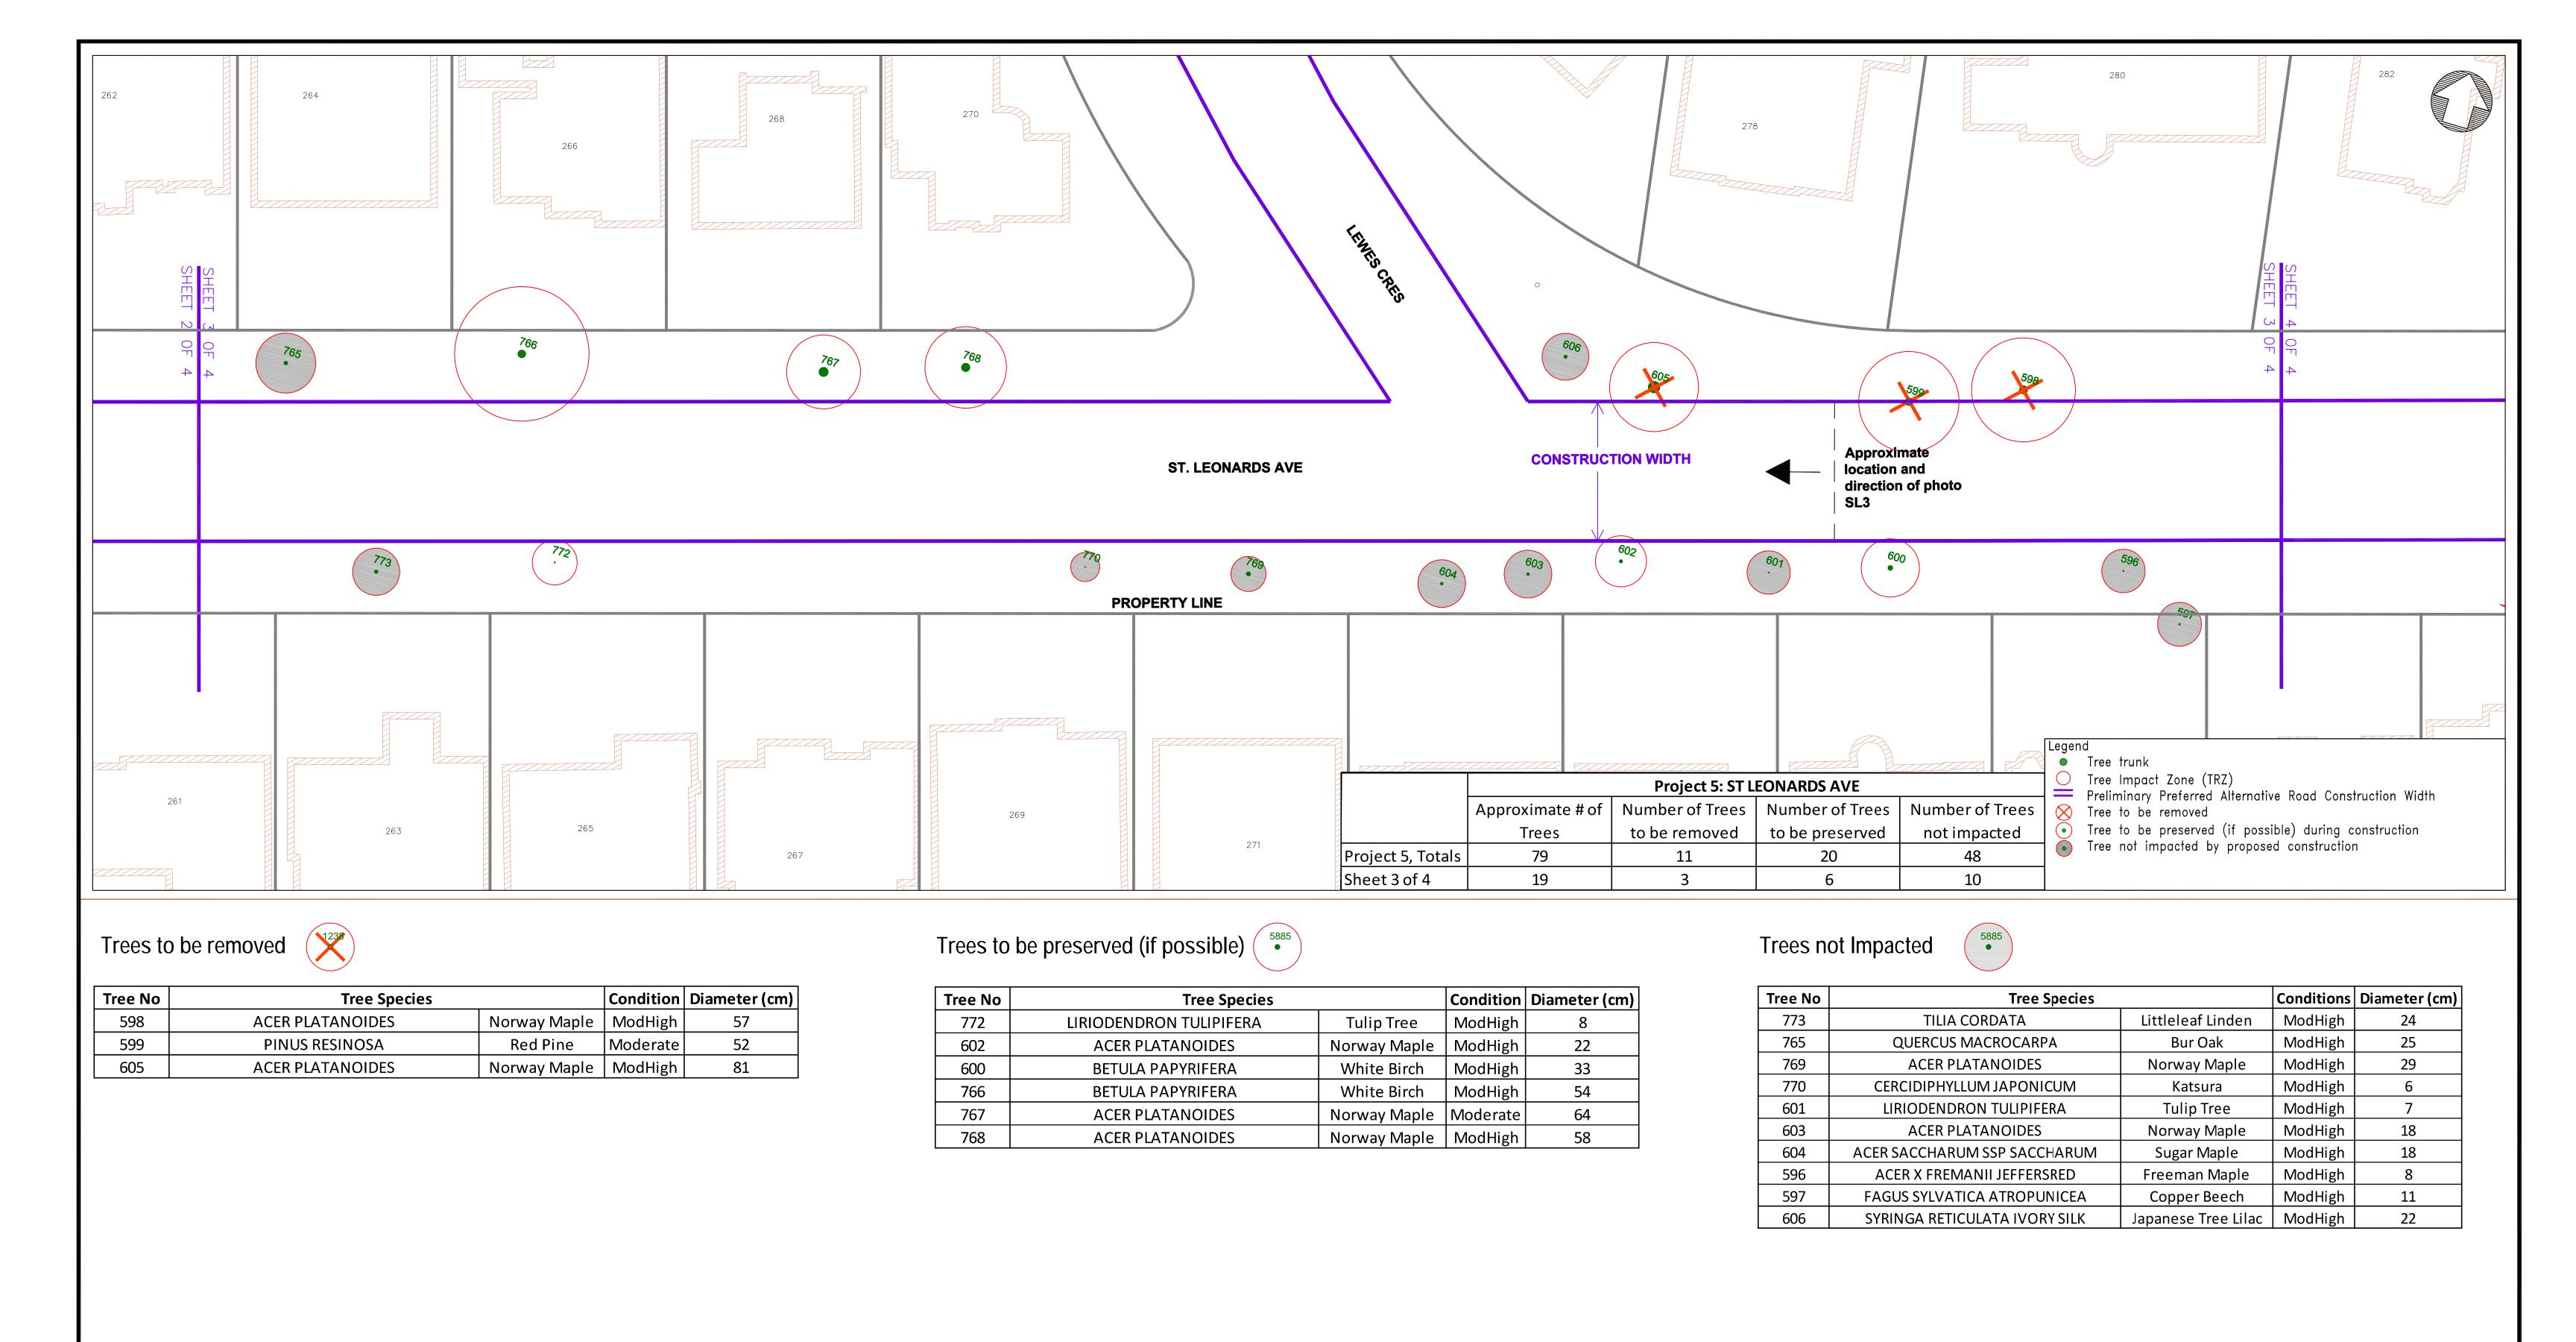

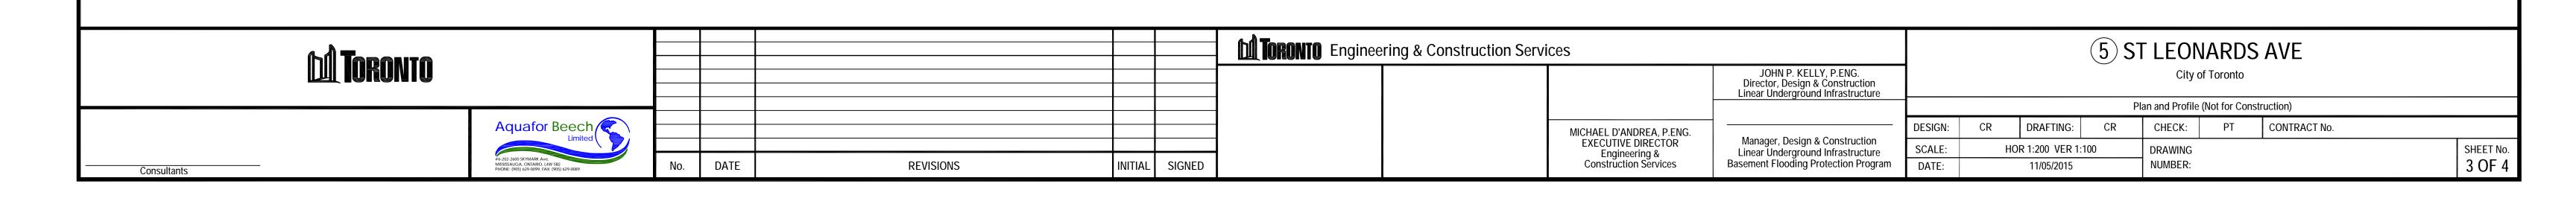

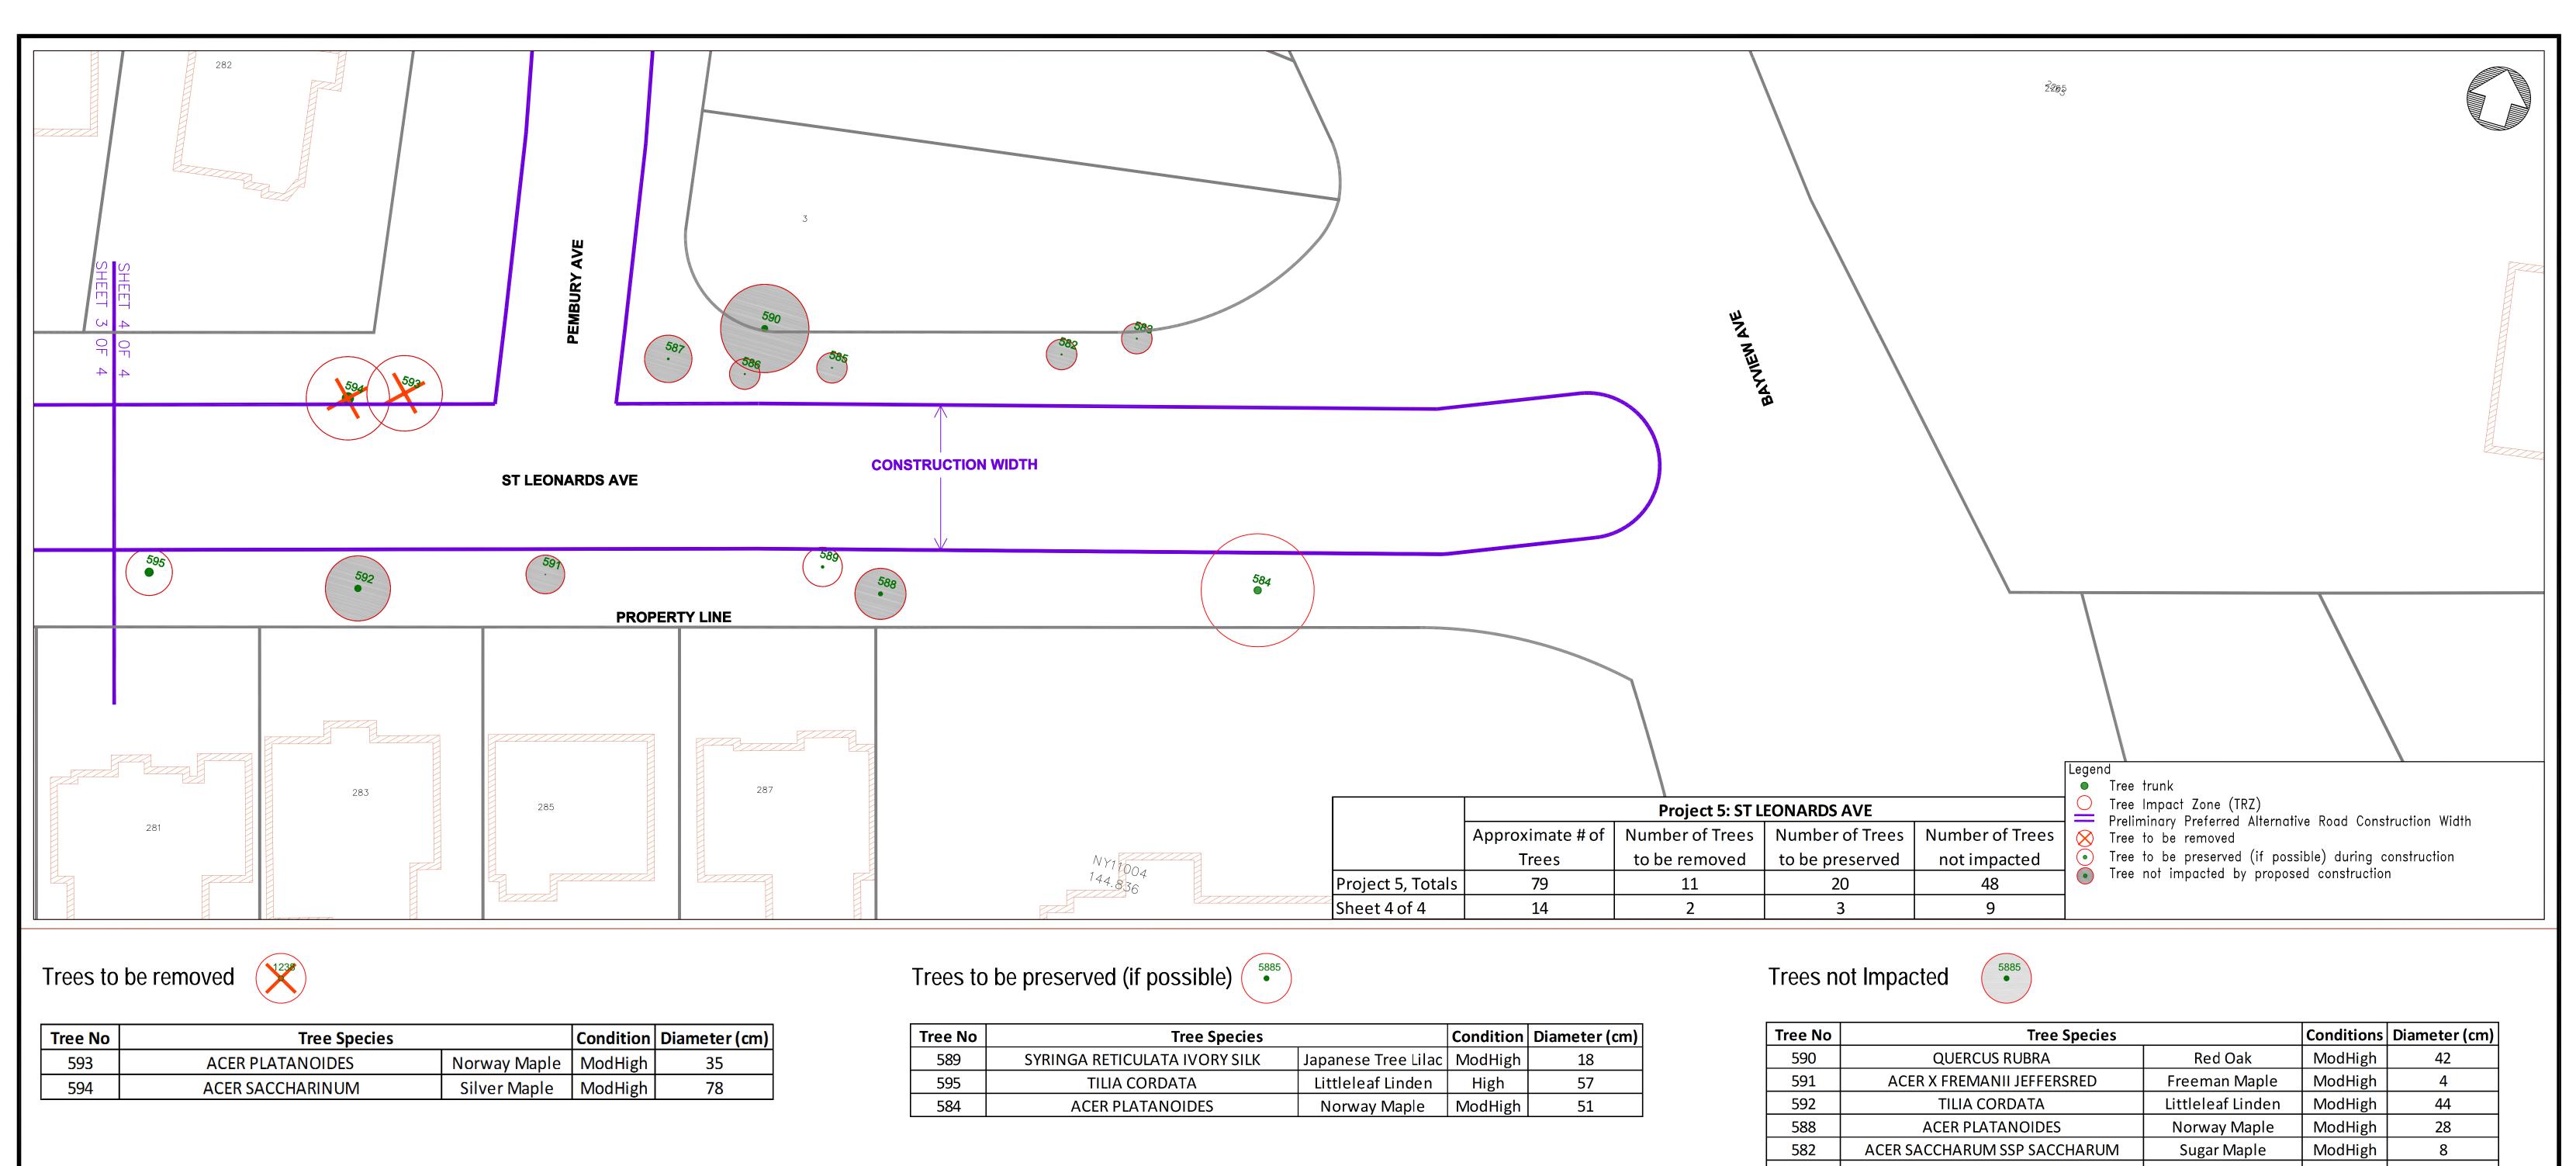

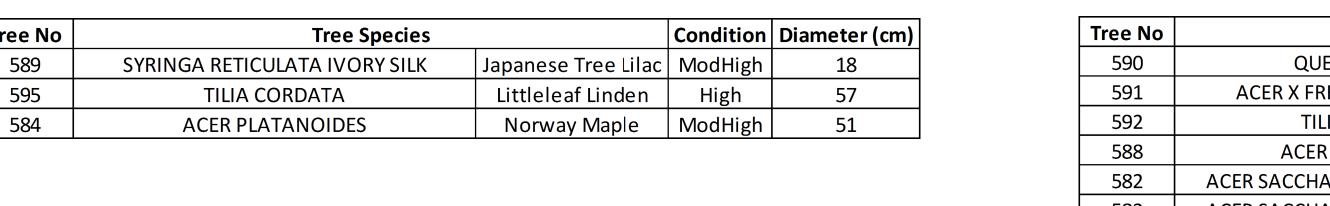

Tree No	Tree Species	Conditions	Diameter (cm)		
590	QUERCUS RUBRA	ModHigh	42		
591	ACER X FREMANII JEFFERSRED	Freeman Maple	ModHigh	4	
592	TILIA CORDATA	Littleleaf Linden	ModHigh	44	
588	ACER PLATANOIDES	Norway Maple	ModHigh	28	
582	ACER SACCHARUM SSP SACCHARUM	Sugar Maple	ModHigh	8	
583	ACER SACCHARUM SSP SACCHARUM	Sugar Maple	ModHigh	8	
585	ACER RUBRUM	Red Maple	ModHigh	7	
586	ACER RUBRUM	Red Maple	ModHigh	8	
587	ACER RUBRUM	Red Maple	ModHigh	13	

M Toronto								TORONTO Engineering & Construction Services			5 ST LEONARDS AVE							
										JOHN P. KELLY, P.ENG. Director, Design & Construction Linear Underground Infrastructure					City o	f Toronto		
											Plan and Profile (Not for Construction)							
Ac	equafor Beech								MICHAEL D'ANDREA, P.ENG.		DESIGN:	CR	DRAFTING:	CR	CHECK:	PT	CONTRACT No.	
	Limited		DATE				_ SIGNED		EXECUTIVE DIRECTOR Engineering & Construction Services	Manager, Design & Construction Linear Underground Infrastructure Basement Flooding Protection Program	SCALE:		HOR 1:200 VER 1:100		DRAWING			SHEET No.
#6-202 MISSISS PHONE	202-2600 SKYMARK Ave, SISSAUCA, ONTARIO, L4W 5B2 DNE: (905) 629-0099, FAX: (905) 629-0089	No.		REVISIONS	INITIA	L :					DATE:		11/05/2015		NUMBER:			4 OF 4